
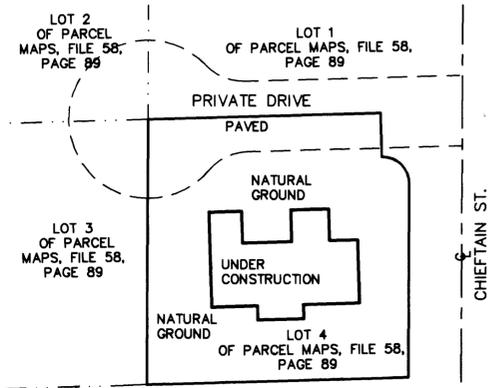


MAP TO ACCOMPANY APPLICATION FOR CHANGE OF PLACE OF USE
AND POINT OF DIVERSION OF
PERMIT NO. 61478

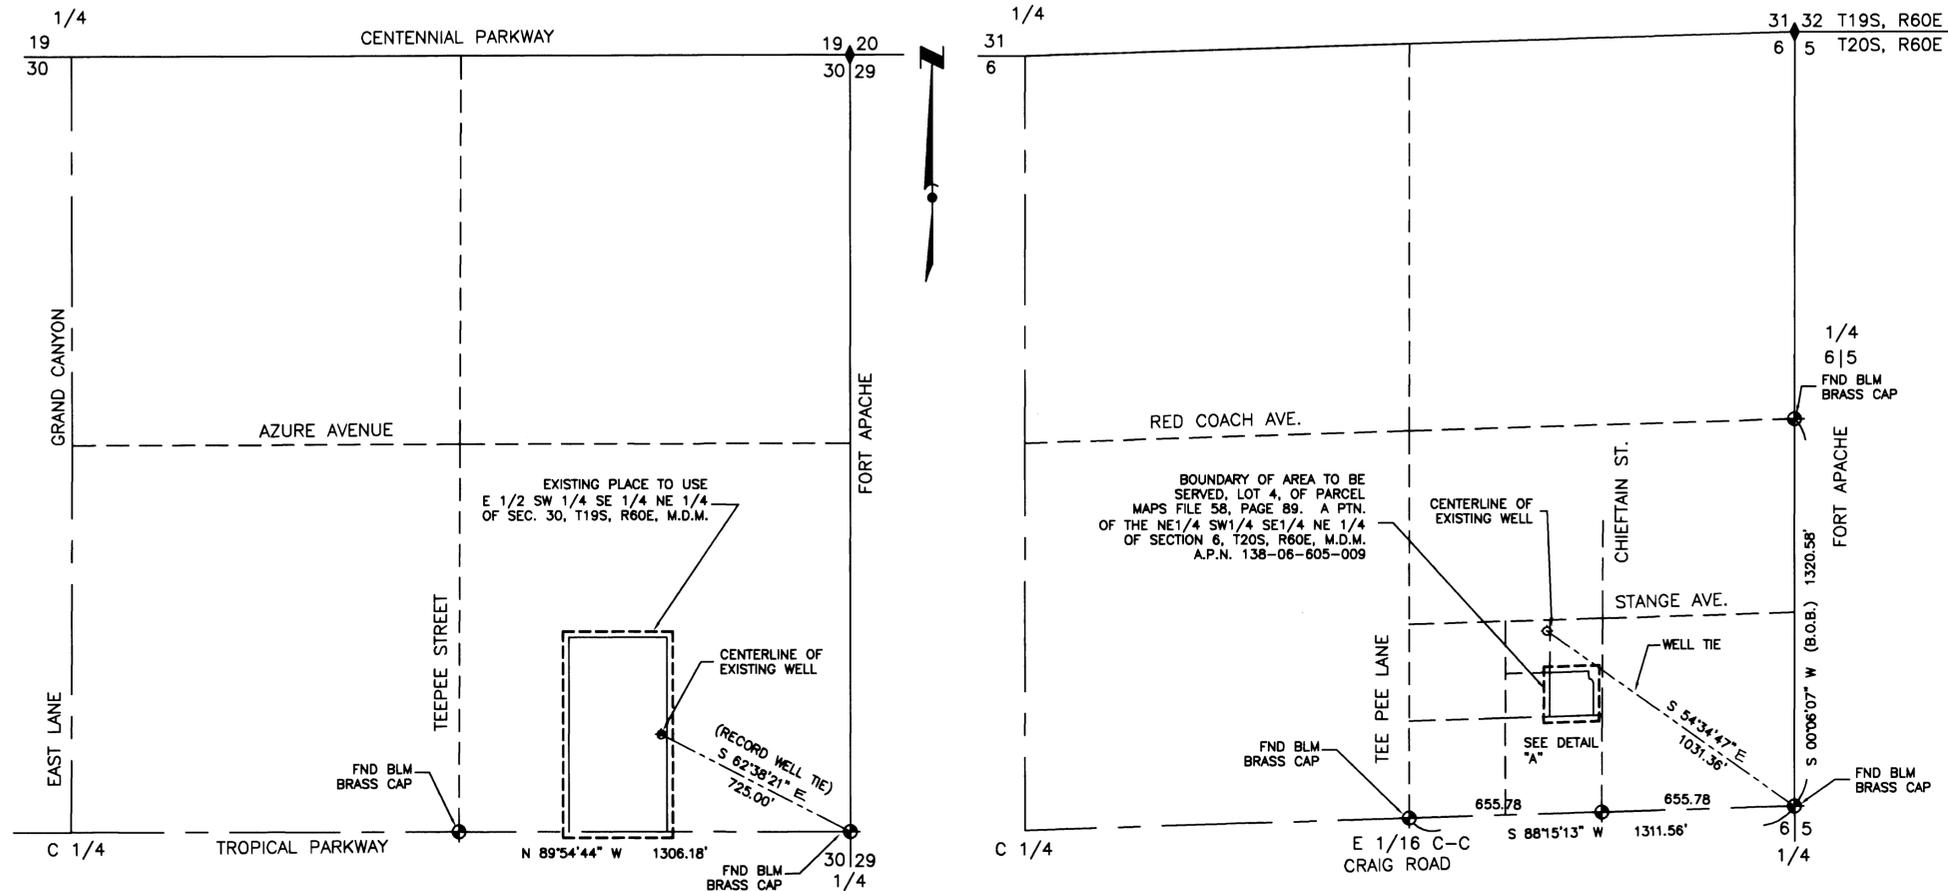


EXISTING PLACE OF USE
A PORTION OF THE SOUTHEAST QUARTER (SE 1/4)
OF THE NORTHEAST QUARTER (NE 1/4) OF
SEC. 30, T19S, R60E, M.D.M.

PROPOSED PLACE OF USE
A PORTION OF THE SOUTHEAST QUARTER (SE 1/4)
OF THE NORTHEAST QUARTER (NE 1/4) SEC. 6, T20S, R60E, M.D.M.


I, ROBERT FULSTONE, BEING FIRST DULY SWORN DEPOSE AND SAY THAT THIS MAP CONSISTING OF ONE SHEET HAS BEEN CORRECTLY DRAWN TO THE DESIGNATED SCALE FROM THE FIELD NOTES OF THE SURVEY MADE UNDER MY SUPERVISION AND DIRECTION ON 10/23/05 AND THAT IS TRULY AND CORRECTLY REPRESENTS THE PROPOSED LOCATION AND EXTENT OF THE WORKS USED TO DIVERT WATER FROM AN UNDERGROUND SOURCE IN THE LAS VEGAS VALLEY BASIN BY CRAIG O. BROOKSBY AND SONJA R. BROOKSBY FOR QUASI-MUNICIPAL USE. THAT THE PROPOSED POINT OF DIVERSION, THE APPROXIMATE LOCATION AND SIZE OF THE DIVERTING CHANNEL OR OTHER CONDUIT, THE PLACE AND MANNER OF USE AND THE LOCATION AND USE OF ALL OTHER STREAMS, WHICH ARE CROSSED OR CONNECTED WITH THE SAID WORKS ARE FULLY AND CORRECTLY DESIGNATED THEREON.

Robert Fulstone
ROBERT FULSTONE
STATE WATER RIGHTS SURVEYOR
NEVADA CERTIFICATE NO. 639

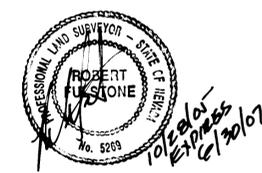

ACKNOWLEDGMENT

 STATE OF NEVADA
COUNTY OF CLARK
THIS INSTRUMENT WAS ACKNOWLEDGED BEFORE ME ON 10/28/2005
BY ROBERT FULSTONE



Ryan P. Skaggs
RYAN P. SKAGGS
NOTARY PUBLIC IN AND FOR SAID COUNTY AND STATE
MY COMMISSION EXPIRES ON FEBRUARY 19, 2008

BASIS OF BEARINGS
S 00°06'07" W BEING THE EAST LINE OF THE SOUTHEAST QUARTER (SE 1/4) OF THE NORTHEAST QUARTER (NE 1/4) SECTION 6, T20S, R60E, M.D.M. PER FILE 58, PAGE 891 OF PARCEL MAPS IN THE OFFICE OF THE COUNTY RECORDER, CLARK COUNTY, NEVADA

- LEGEND
- ◆ POINTS FOUND AS SHOWN
 - ◆ EXISTING WELL SITE
 - B.O.B. BASIS OF BEARING

STATE ENGINEER'S USE

FILED
MAR 13 2008
STATE ENGINEER'S OFFICE

MAP TO ACCOMPANY APPLICATION FOR CHANGE OF PLACE OF USE AND POINT OF DIVERSION OF PERMIT # 61478

FOR: CRAIG O. BROOKSBY AND SONJA R. BROOKSBY
PURPOSE: QUASI-MUNICIPAL
FROM: AN UNDERGROUND SOURCE IN CLARK COUNTY, NEVADA

DRAWN BY: MONARCH DESIGN
DATE: 10/28/2005
DWG #: SSI-07
FILE NAME: 4019WRT.DWG
SCALE: 1" = 300'

FULSTONE ENTERPRISES
940 S. MARTIN L. KING BOULEVARD
LAS VEGAS, NV 89106
PHONE (702) 382-8141 FAX (702) 382-3103
EMAIL: fei@fulstone.lvcxmail.com

