
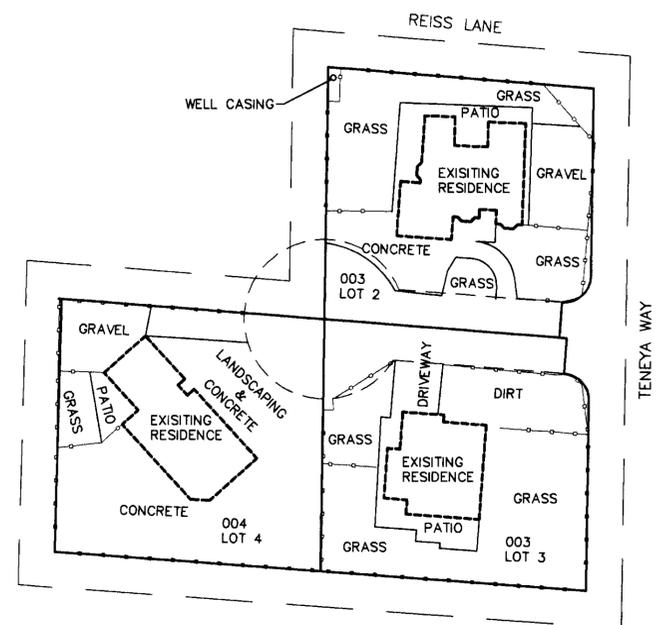


MAP TO ACCOMPANY APPLICATION FOR CHANGE OF PLACE OF USE
AND POINT OF DIVERSION OF A PORTION OF PERMIT NO. 24582
CERTIFICATE NO. 7673

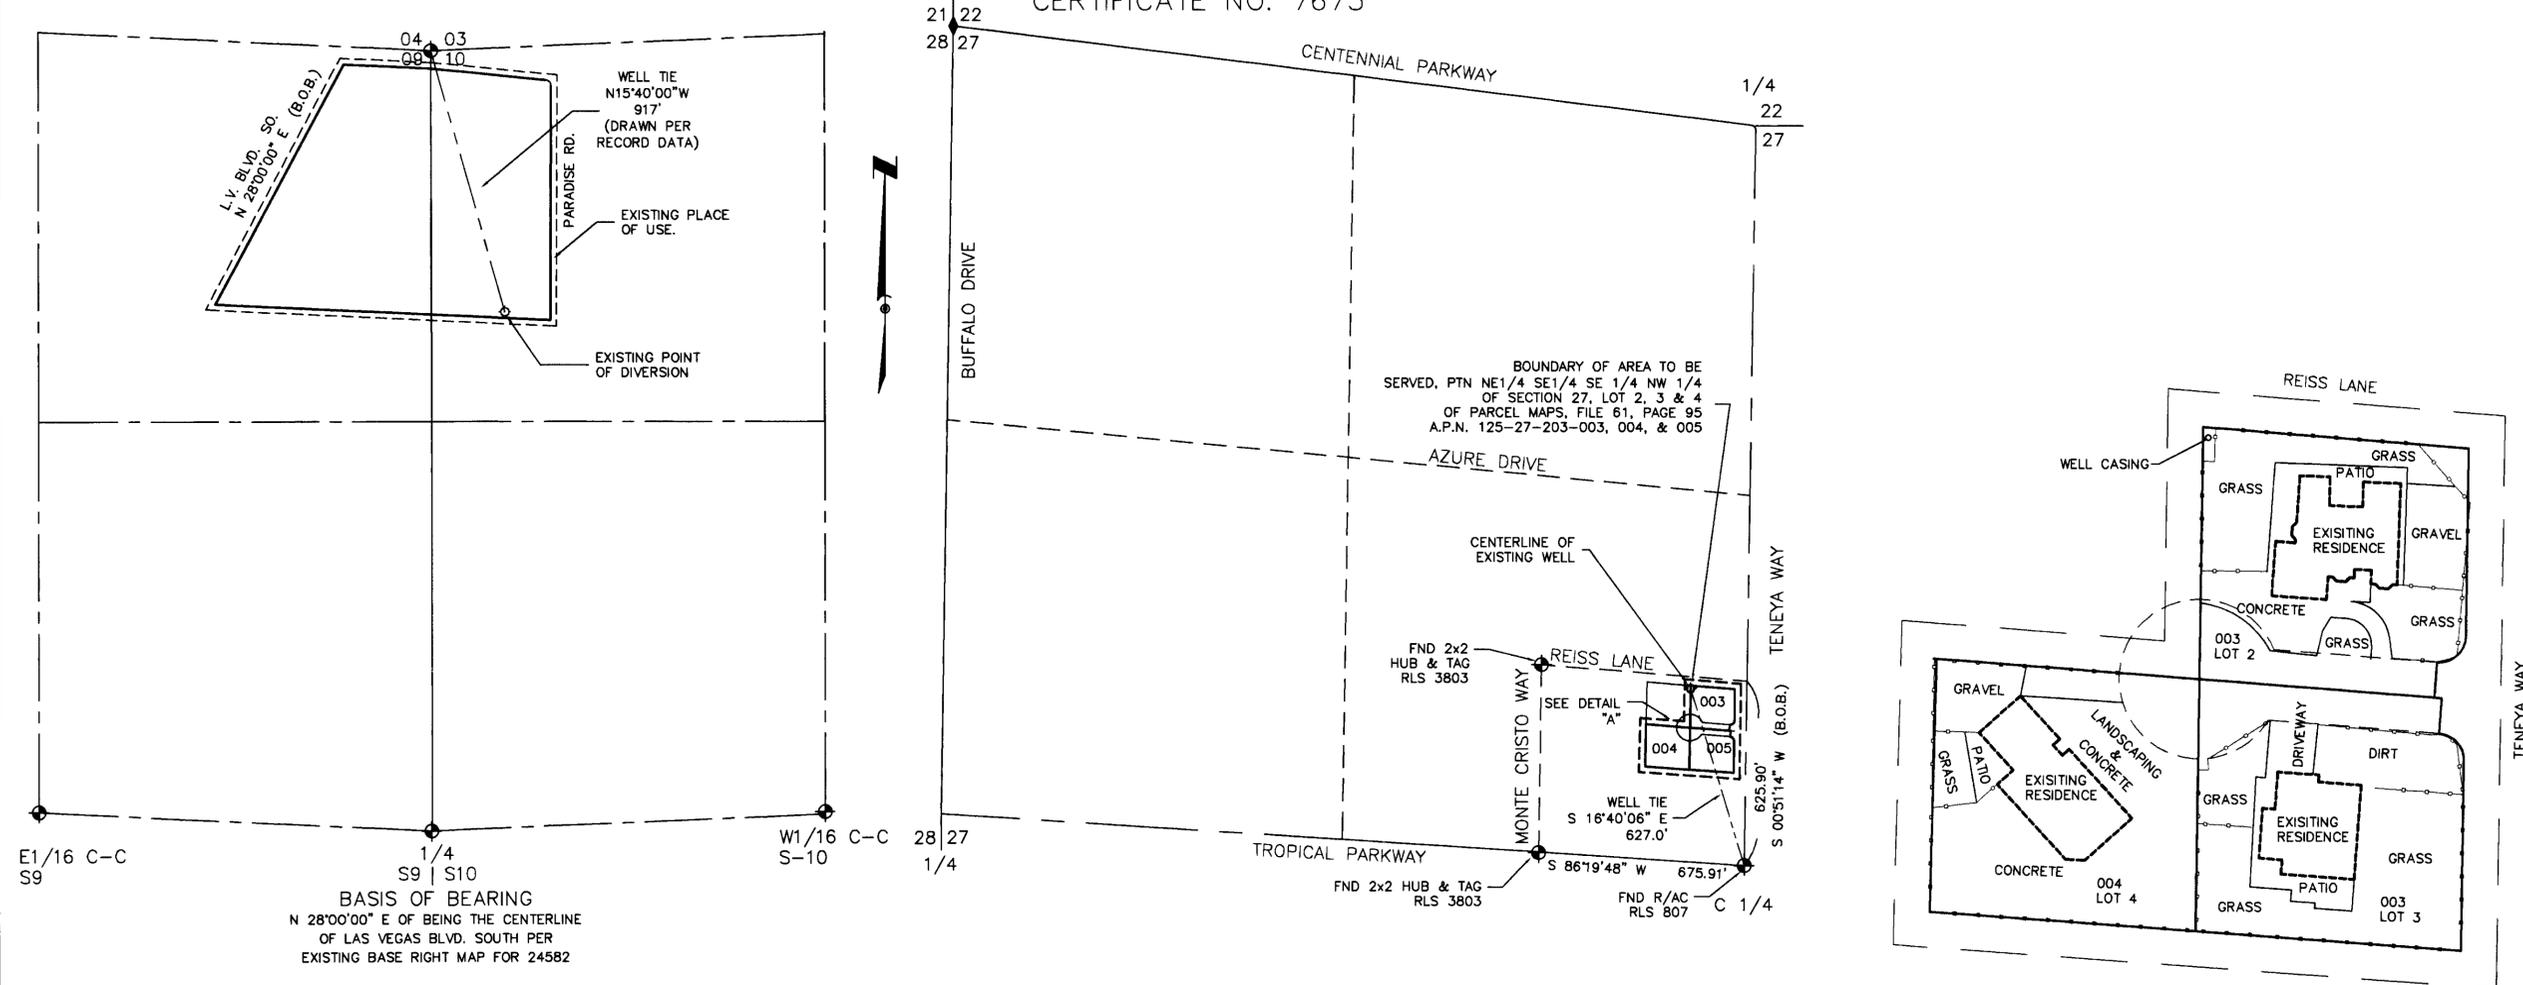

DETAIL "A"
SCALE: 1" = 50'

EXISTING PLACE OF USE
A PORTION OF THE NORTHEAST QUARTER (NE 1/4) OF THE NORTHEAST QUARTER (NE 1/4) OF SECTION 9 AND A PORTION OF THE NORTHWEST QUARTER (NW 1/4) OF THE NORTHWEST QUARTER (NW 1/4) OF SECTION 10, TOWNSHIP 21 SOUTH, RANGE 61 EAST, M.D.M.

PROPOSED PLACE OF USE
A PORTION OF THE SOUTHEAST QUARTER (SE 1/4) OF THE NORTHWEST QUARTER (NW 1/4) OF SECTION 27, TOWNSHIP 19 SOUTH, RANGE 60 EAST, M.D.M.

 
I, ROBERT FULSTONE, BEING FIRST DULY SWORN DEPOSE AND SAY THAT THIS MAP CONSISTING OF ONE SHEET HAS BEEN CORRECTLY DRAWN TO THE DESIGNATED SCALE FROM THE FIELD NOTES OF THE SURVEY MADE UNDER MY SUPERVISION AND DIRECTION ON 02/20/06 AND THAT IS TRULY AND CORRECTLY REPRESENTS THE PROPOSED LOCATION AND EXTENT OF THE WORKS USED TO DIVERT WATER FROM AN UNDERGROUND SOURCE IN THE LAS VEGAS VALLEY BASIN BY ROBERT P. LACKER AND MARY A. LACKER FOR QUASI-MUNICIPAL USE, THAT THE PROPOSED POINT OF DIVERSION, THE APPROXIMATE LOCATION AND SIZE OF THE DIVERTING CHANNEL OR OTHER CONDUIT, THE PLACE AND MANNER OF USE AND THE LOCATION AND USE OF ALL OTHER STREAMS, WHICH ARE CROSSED OR CONNECTED WITH THE SAID WORKS ARE FULLY AND CORRECTLY DESIGNATED THEREON.

ROBERT FULSTONE
STATE WATER RIGHTS SURVEYOR
NEVADA CERTIFICATE NO. 639



ACKNOWLEDGMENT

STATE OF NEVADA
COUNTY OF CLARK
THIS INSTRUMENT WAS ACKNOWLEDGED BEFORE ME ON 02/07/2006
BY ROBERT FULSTONE




RYAN P. SKAGGS
NOTARY PUBLIC IN AND FOR SAID COUNTY AND STATE
MY COMMISSION EXPIRES ON FEBRUARY 19, 2008

73814 CERTIFICATE NO. 2-1-08 ISSUED 9-20-11

BASIS OF BEARINGS
S 00°51'14" W BEING THE EAST LINE OF THE SOUTHEAST QUARTER (SE 1/4) OF THE SOUTHEAST QUARTER (SE 1/4) OF THE NORTHWEST QUARTER (NW 1/4) OF SECTION 27, TOWNSHIP 19 SOUTH, RANGE 60 EAST, M.D.M. PER FILE 61, PAGE 95 OF PARCEL MAPS IN THE OFFICE OF THE COUNTY RECORDER, CLARK COUNTY, NEVADA

 - LEGEND**
- ◆ POINTS FOUND AS SHOWN
 - ⊕ PROPOSED WELL SITE
 - B.O.B. BASIS OF BEARING



DRAWN BY: MONARCH DESIGN
DATE: 01/20/2006
DWG #: SSI-29
FILE NAME: 3194WRT.DWG
SCALE: 1" = 300'

FULSTONE ENTERPRISES
940 S. MARTIN L. KING BOULEVARD
LAS VEGAS, NV 89106
PHONE (702) 382-8141 FAX (702) 382-3103
EMAIL: fe@fulstone.lvcoxmail.com

STATE ENGINEER'S USE

2-23-06 BAR SCALE IN CORRECT
1" = 300'

FEB 21 2006

MAP TO ACCOMPANY APPLICATION FOR CHANGE OF PLACE OF USE AND POINT OF DIVERSION OF A PORTION OF PERMIT # 24582 CERTIFICATE NO. 7673

FOR: ROBERT P. LACKER AND MARY A. LACKER
PURPOSE: QUASI-MUNICIPAL
FROM: AN UNDERGROUND SOURCE IN CLARK COUNTY, NEVADA