


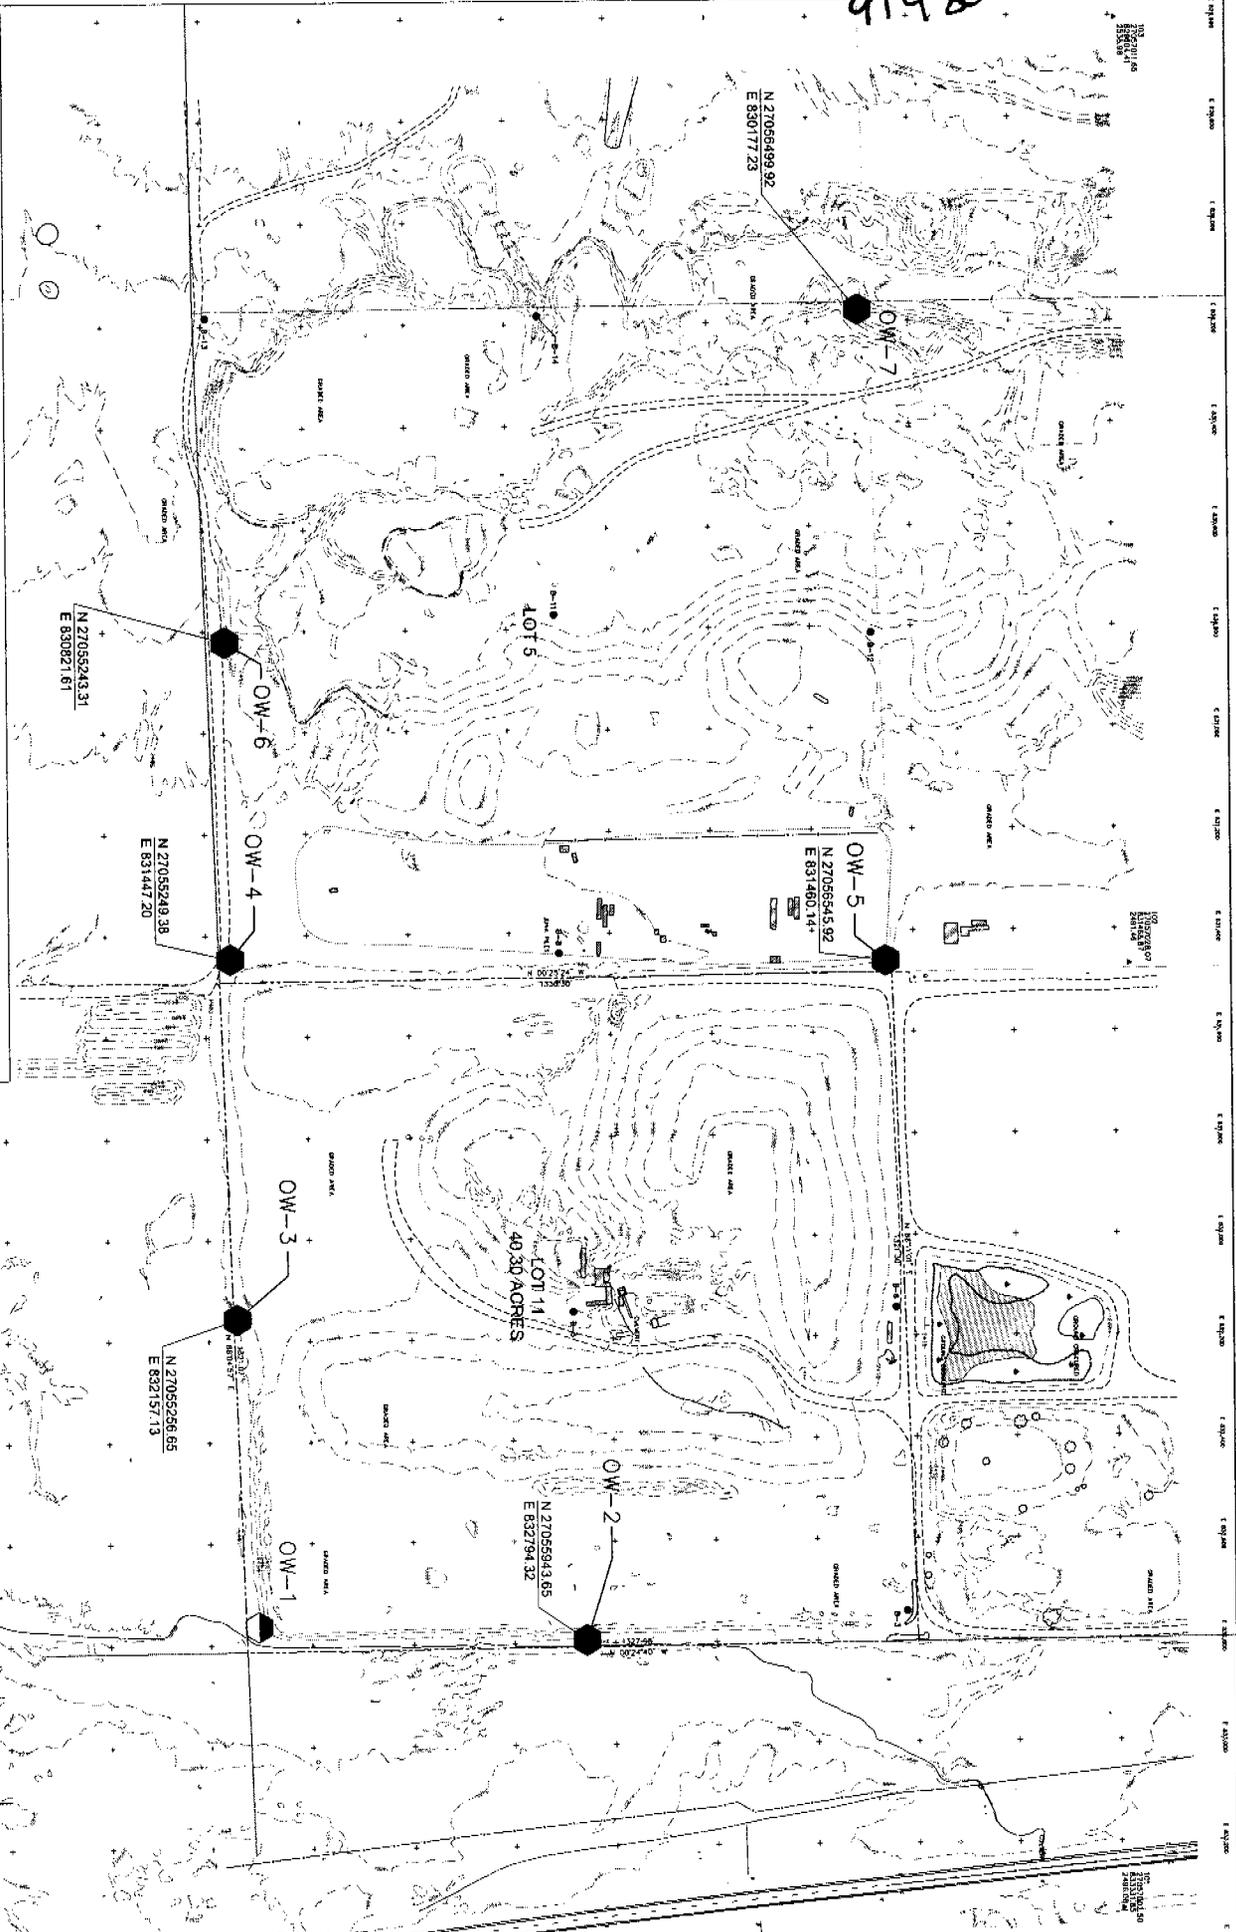

91480



**LEGEND**

- 
 OW-1  
 EXISTING MONITORING WELL LOCATION AND IDENTIFICATION
- 
 OW-2  
 PROPOSED MONITORING WELL LOCATION AND IDENTIFICATION



**NOTES**

1. MONITORING WELLS FOR PROPOSED MONITORING IDENTIFIED FROM SITE PLAN.
2. MONITORING WELLS FOR EXISTING MONITORING IDENTIFIED FROM SITE PLAN.
3. MONITORING WELLS FOR PROPOSED MONITORING IDENTIFIED FROM SITE PLAN.
4. MONITORING WELLS FOR EXISTING MONITORING IDENTIFIED FROM SITE PLAN.
5. MONITORING WELLS FOR PROPOSED MONITORING IDENTIFIED FROM SITE PLAN.
6. MONITORING WELLS FOR EXISTING MONITORING IDENTIFIED FROM SITE PLAN.
7. MONITORING WELLS FOR PROPOSED MONITORING IDENTIFIED FROM SITE PLAN.
8. MONITORING WELLS FOR EXISTING MONITORING IDENTIFIED FROM SITE PLAN.
9. MONITORING WELLS FOR PROPOSED MONITORING IDENTIFIED FROM SITE PLAN.
10. MONITORING WELLS FOR EXISTING MONITORING IDENTIFIED FROM SITE PLAN.

WESTERN ELITE, INC.  
LINCOLN COUNTY, NEVADA

**SITE PLAN**

**WEME**  
ENGINEERING, INC.  
10000 W. BROADWAY  
SUITE 100  
DENVER, CO 80231  
PHONE (303) 750-4500

DESIGNED BY: [ ]  
DRAWN BY: [ ]  
CHECKED BY: [ ]  
APPROVED BY: [ ]  
DATE: 11/73/83

DATE	REVISIONS AND RECORD OF ISSUE	NO	BY	OK	APP	REVISIONS AND RECORD OF ISSUE	NO	BY	OK	APP

PROJECT NO. 383.00.06  
SCALE AS SHOWN  
DRAWING NO. 1